


1 ELEC GF
1 : 100

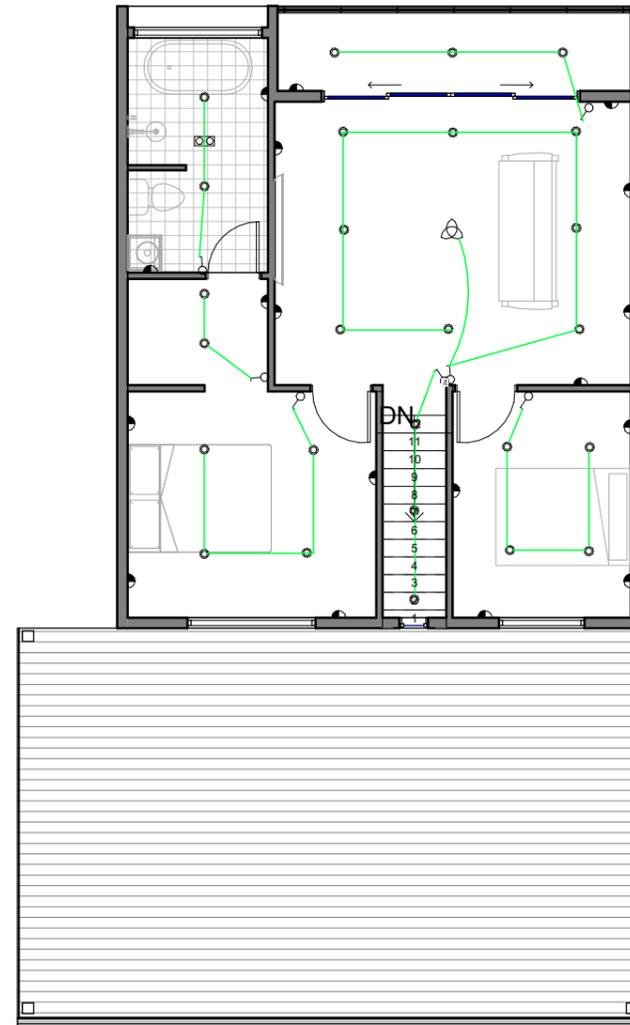

2 ELEC FF
1 : 100

ELECTRICAL LEGENDS

-  GPO DOUBLE
-  LIGHT SWITCH
-  2 WAY LIGHT SWITCH
-  APPLIANCE CONNECTION POINT
-  SMOKE DETECTOR
-  MAIN DISTRIBUTION
-  INTERNET CABLE
-  PHONE POINT
-  TV POINT
-  INTERCOM
-  FAN

LIGHTING LEGENDS

-  RECESSED DOWNLIGHT
-  MOTION SENSOR
-  UNDER LED STRIP LIGHT
-  3 IN 1
-  WALL LIGHT
-  EXHAUST FAN
-  FLOOD LIGHT
-  MIRROR LIGHT

REV.	DESCRIPTION	DATE	DATE
001		09/03/25	3/09/2025 11:17:59 AM
		DRAWN BY Author	CHECKED BY Checker
		SCALE AS SHOWN@A3	SHEET NO A11